
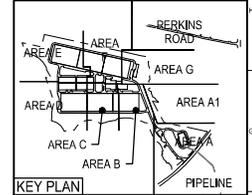


NOTE:
SEE CS-DRAWING SERIES FOR STORMWATER SYSTEM INFORMATION.

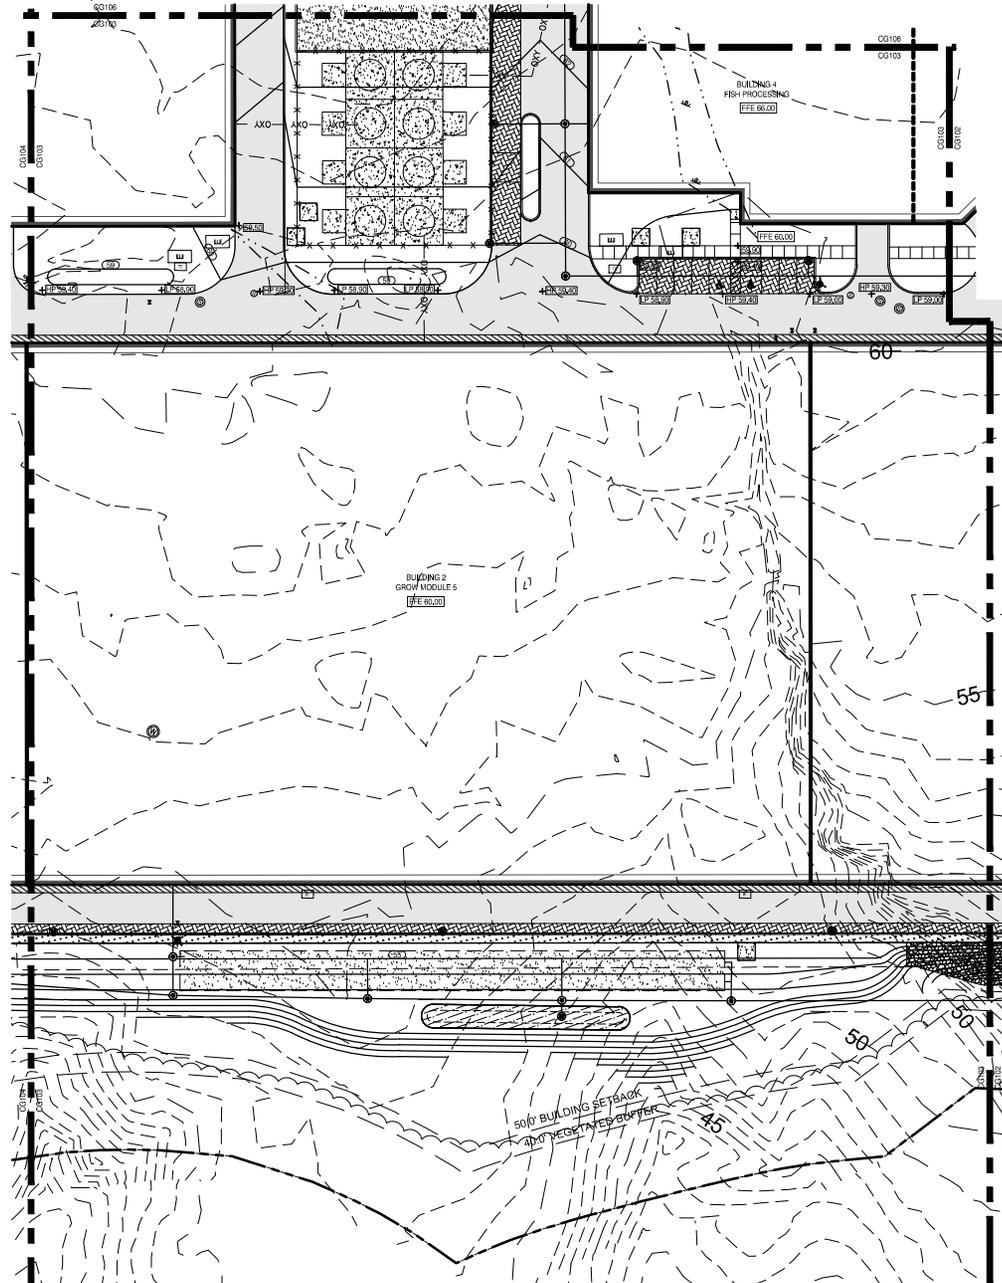

REV	DESCRIPTION	DATE
0	ISSUED FOR PERMIT	5-14-19

TRUE NORTH

SMRT Architects and Engineers
144 Fore Street P.O. Box 618
Portland, Maine 04104
1.877.700.7678
www.smrtinc.com

ANSOM Consulting Engineers and Scientists
Ransom Consulting Engineers and Scientists
405 Commercial Street, Suite 400
Portland, Maine 04101

NORDIC AQUAFARMS
285 NORTHPORT AVENUE

BELFAST, MAINE
GRADING PLAN
AREA C

SHEET TITLE:

SCALE: 1" = 30'

PROJECT MANAGER:	ADB	PROJECT NO.:	18076
A.E. OF RECORD:	MSJ		
JOB CAPTAIN:	SP		
DRAWN BY:	WSM		

CG103

SMRT FILE: CG103-18076 SHEET No. 03

NOT FOR CONSTRUCTION