
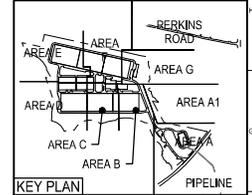


NOTE:  
SEE CS-DRAWING SERIES FOR STORMWATER SYSTEM INFORMATION.

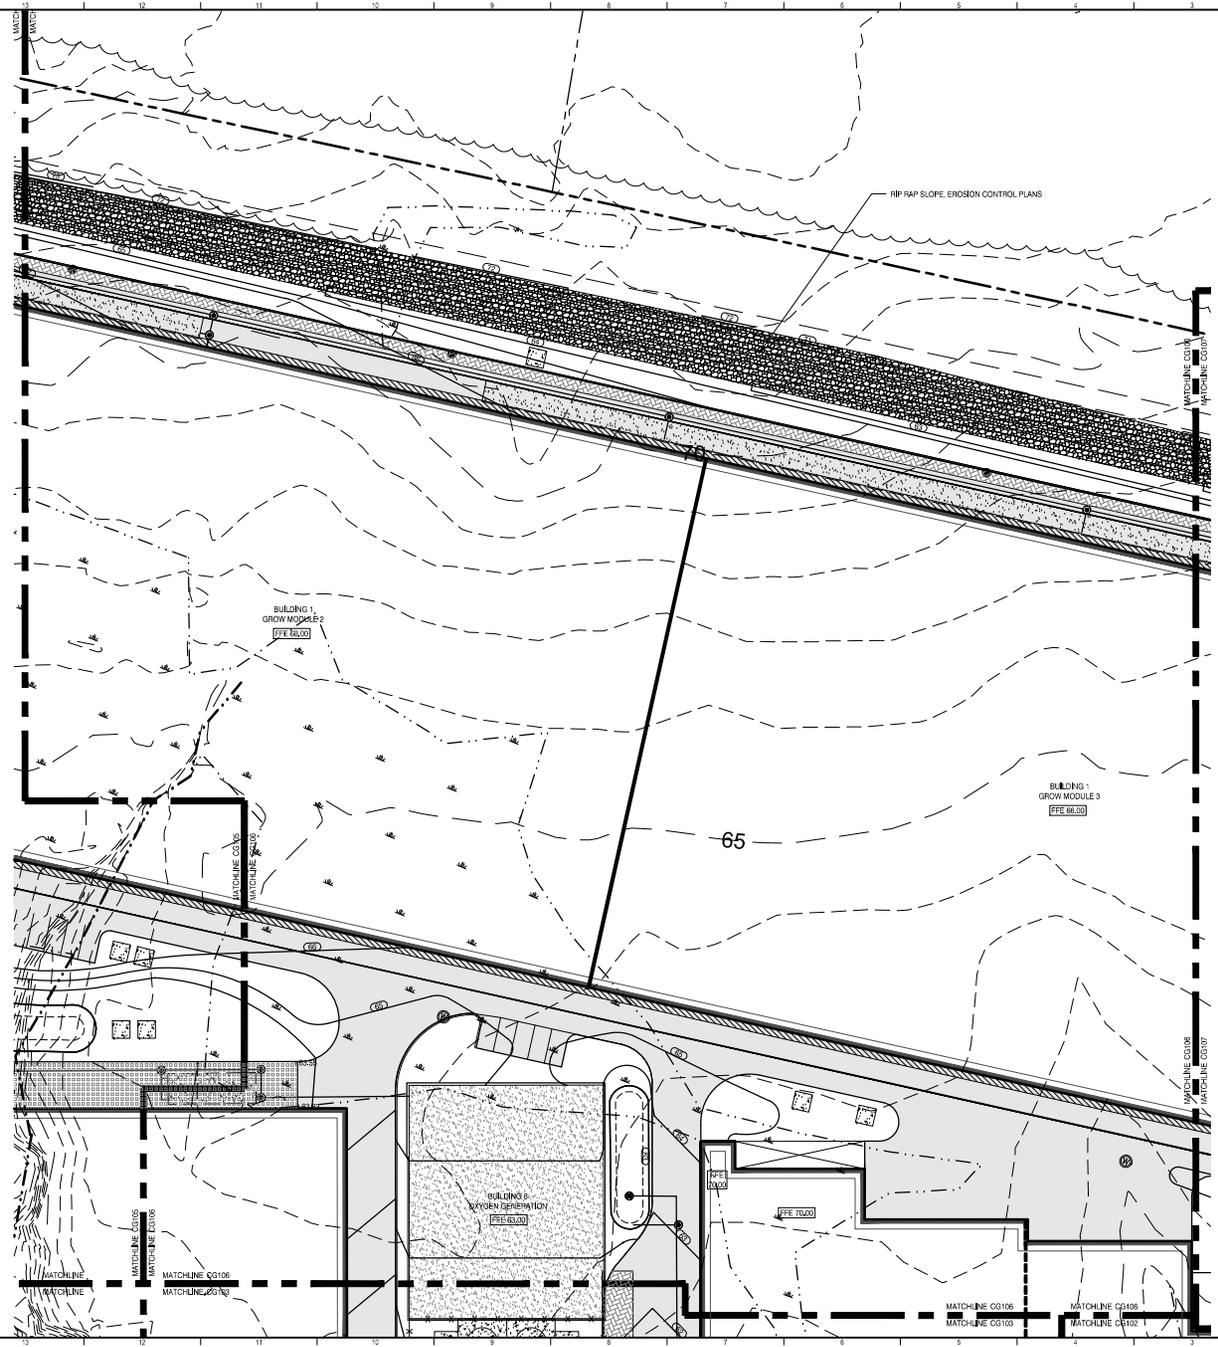

REV	DESCRIPTION	DATE
3	ISSUED FOR PERMIT	5-14-19
2		
1		

TRUE NORTH

SMRT Architects and Engineers  
144 Fore Street P.O. Box 618  
Portland, Maine 04104  
1.877.700.7678  
www.smrtinc.com

**ANSOM** Consulting Engineers and Scientists  
Ransom Consulting Engineers and Scientists  
405 Commercial Street, Suite 400  
Portland, Maine 04101

**NORDIC AQUAFARMS**  
285 NORTHPORT AVENUE

BELFAST, MAINE  
**GRADING PLAN**  
AREA F

SHEET TITLE:

SCALE: 1" = 30'

PROJECT MANAGER	ADB	PROJECT NO.	18076
AE OF RECORD:			
JOB CAPTAIN:	SP		
DRAWN BY:	WSM		
SMRT FILE:	CG106-18076	SHEET No.	CG106

NOT FOR CONSTRUCTION