
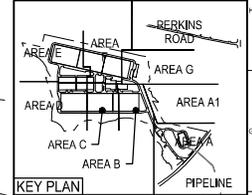


NOTE:
SEE CS-DRAWING SERIES FOR STORMWATER SYSTEM INFORMATION.

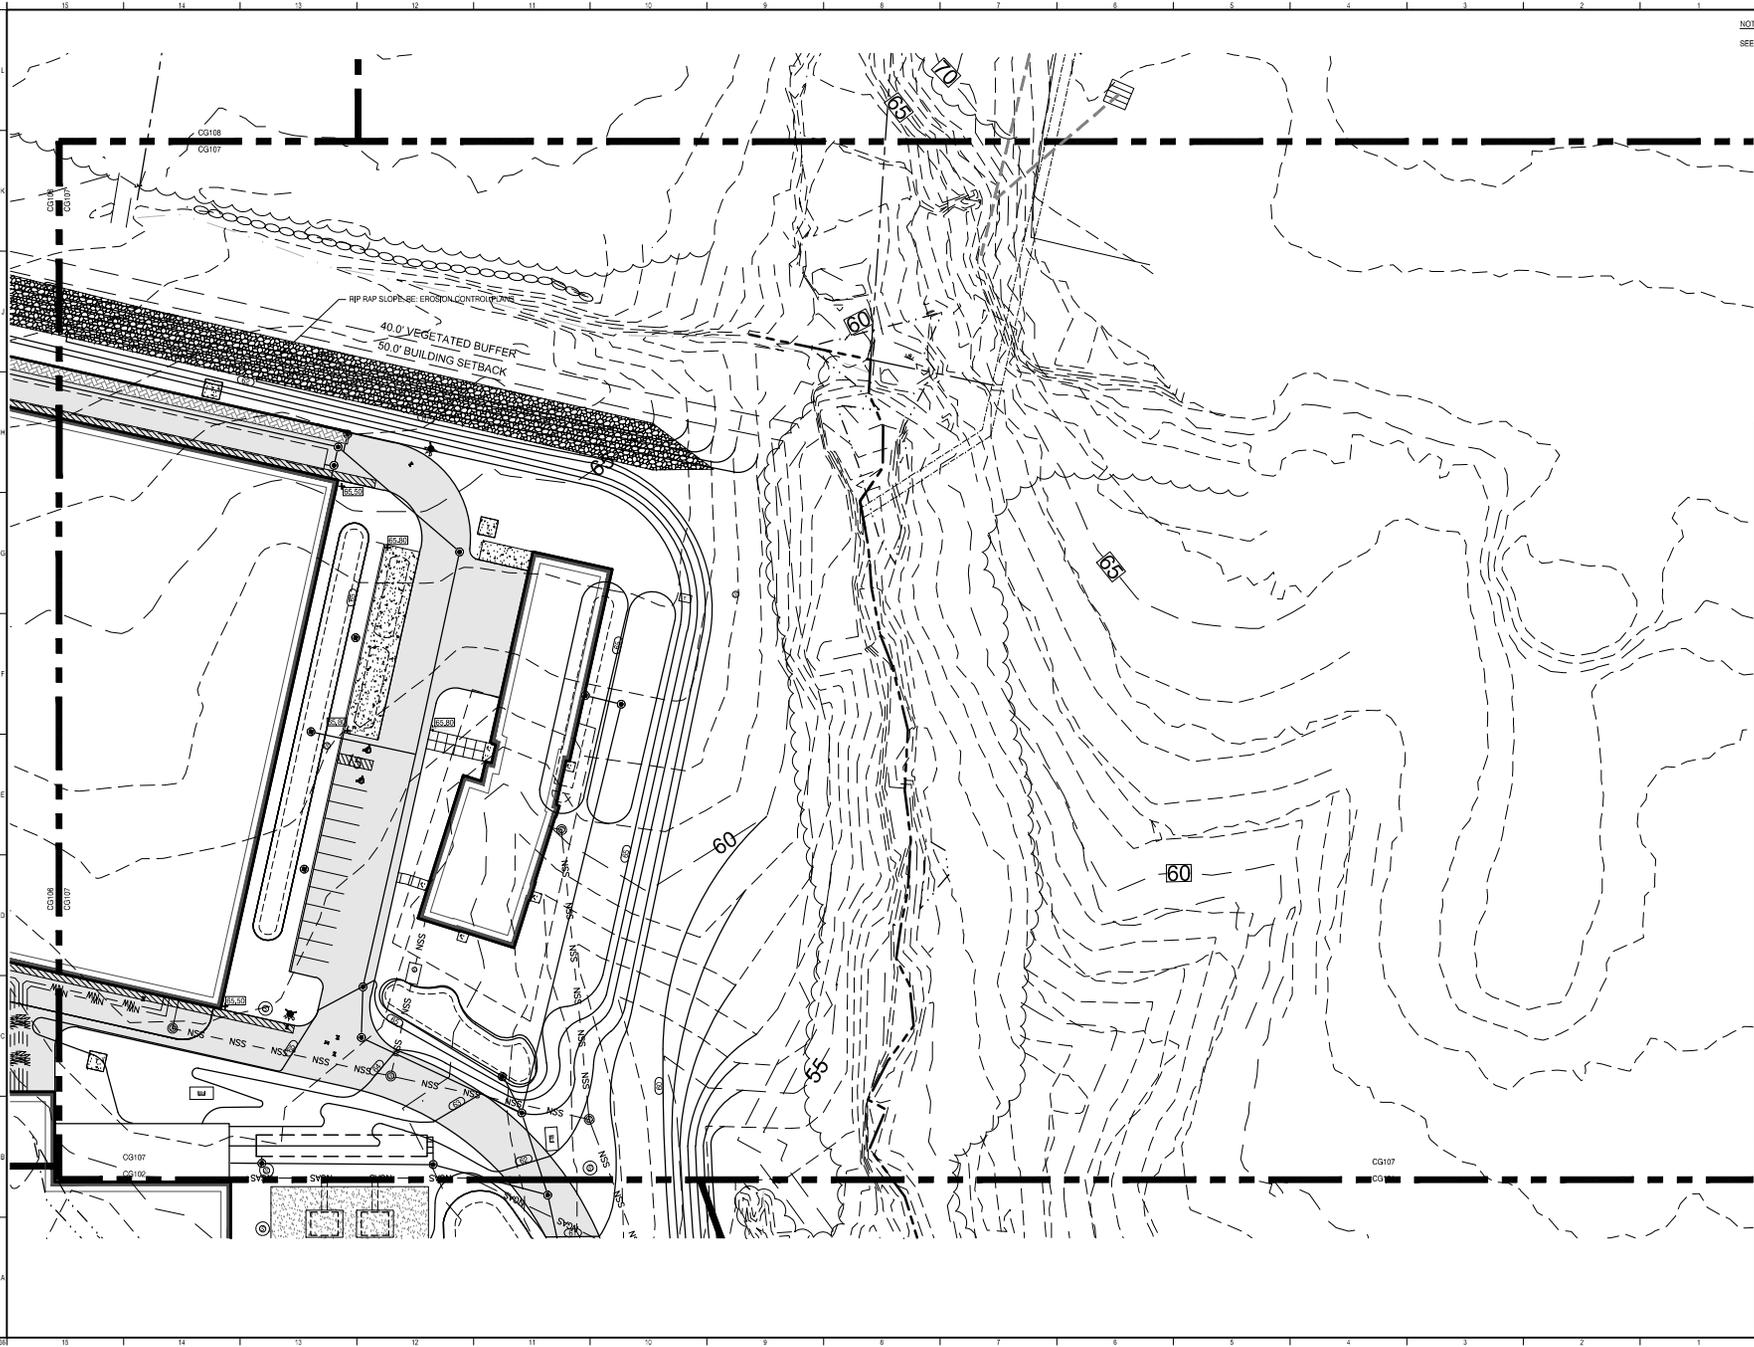

NO.	ISSUED FOR PERMIT	DATE
3	ISSUED FOR PERMIT	5-14-19
REV.	DESCRIPTION	DATE

TRUE NORTH

SMRT Architects and Engineers
144 Fore Street P.O. Box 618
Portland, Maine 04104
1.877.700.7678
www.smrtinc.com

ANSOM Consulting Engineers and Scientists
Ransom Consulting Engineers and Scientists
400 Commercial Street, Suite 400
Portland, Maine 04101

NORDIC AQUAFARMS
285 NORTHPORT AVENUE
BELFAST, MAINE

GRADING PLAN
AREA G

SHEET TITLE:

SCALE: 1" = 30'

PROJECT MANAGER:	ADB	PROJECT NO.:	18076
AE OF RECORD:			
JOB CAPTAIN:	SP		
DRAWN BY:	WSM		
SMRT FILE:	CG107-18076	SHEET No.:	CG107

NOT FOR CONSTRUCTION